

**SITE PLAN**

Coloara Township, Lake County, Ohio

**FOR:** KAY HORNES OWNER  
221 SUTHERLAND DR. COLORA  
 ADDRESS STREET CITY ZIP

UNREGISTERED SUB No 3  
 SUBDIVISION 5-51 NAME  
 VOL. PG. NAME  
 42 12244 DE  
 SUBLOT NO. STREET

LOT	TRACT
VOLUME	PAGE
PERM. PARCEL NO.	STREET

**LEGEND**

SANITARY MANHOLE WATER VALVE (GAS) 
  
 STORM MANHOLE WATER METER (GAS) 
  
 INLET OR CATCH BASIN AS BUILT ELEVATION 
  
 HYDRANT 
  
 EXISTING CONTOURS 
  
 PROPOSED CONTOURS INDICATES DIRECTION OF SURFACE DRAINAGE 
  
 EXIST. ELEV. 5 PROP. ELEV. 100.0

**REMARKS**

ALL BOUNDARY DATA SHOWN WAS OBTAINED FROM (DEEDS, RECORDED SUBDIVISION PLAT OR OTHER PUBLIC RECORDS)

LOCATIONS AS SHOWN OF ADJACENT WELLS AND SEPTIC TANKS OBTAINED FROM LAKE COUNTY HEALTH DEPARTMENT

**DESIGN CERTIFICATION**

THIS PLAN WAS PREPARED BY ME, AND IS CORRECT TO THE BEST OF MY KNOWLEDGE AND BELIEF.

NAME Thomas P. Jones SUPERVISOR REGISTRATION NO. 6843

**CHECK LIST**

NO. OF BEDROOMS	WATER MAIN SIZE, LOCATION
DIMENSIONS	SAN. SEWER SIZE % GR. LOC.
BEARINGS	SAN. MH. CAST. ELEV. INV. ELEV.
THE TO NEAREST STREET	SAN. CONN. SIZE, LOC. DEPTH
SUBLOT NO. PARCEL NO.	STORM SEWER SIZE % GR. LOC.
BLDG. DIMENSIONS OWNERS	STORM MH. CAST ELEV. INV. ELEV.
BLDG. DIMENSIONS FIN. GR.	PAVT TYPE GRADE CURBS
APRON TYPE WIDTH THICKNESS	GAS LINE LOC. SIZE PRESSURE
SEWERAL TYPE WIDTH THICKNESS	SEPTIC TANK LOCATION & DUPLICATION AREA
CULVERT TYPE DIA. LENGTH	WELL LOCATION
ROCK OUTCROPPINGS	ISOLATION RADIUS FROM WELL

PLAN PREPARED BY: BABCOCK • JONES & ASSOCIATES, INC.  
 PAINESVILLE OHIO

NO.	DATE	BY
1		
2		
3		
4		
5		

DRAWN BY HG SCALE 1" = 30' PHONE NO. 357-1811  
 CHK'D. HT DATE 10/28/87 DRAWING NO.  
 CREW CHIEF LD APP'D. LD 83-086-43

"AS BUILT" CERTIFICATION

I, HEREBY CERTIFY THAT THE CIRCLED GRADES ARE EXISTING FINISH GRADES CHECKED IN THE FIELD ON 19 19

AND ARE CORRECT TO THE BEST OF MY KNOWLEDGE AND BELIEF.


REGISTERED SURVEYOR REG. NO.

T.B.M. - RIM SHOWN  
 ELEV. - 775.60

ZONING PERMIT #5625  
 ISSUED 9-2-87

SUBJECT TO APPROVAL BY:  
 Lake County Sanitary Eng.  
 Lake County Eng. Dept.  
 Lake County Planning Comm.  
 Lake County Bldg. Dept.

Thomas P. Jones

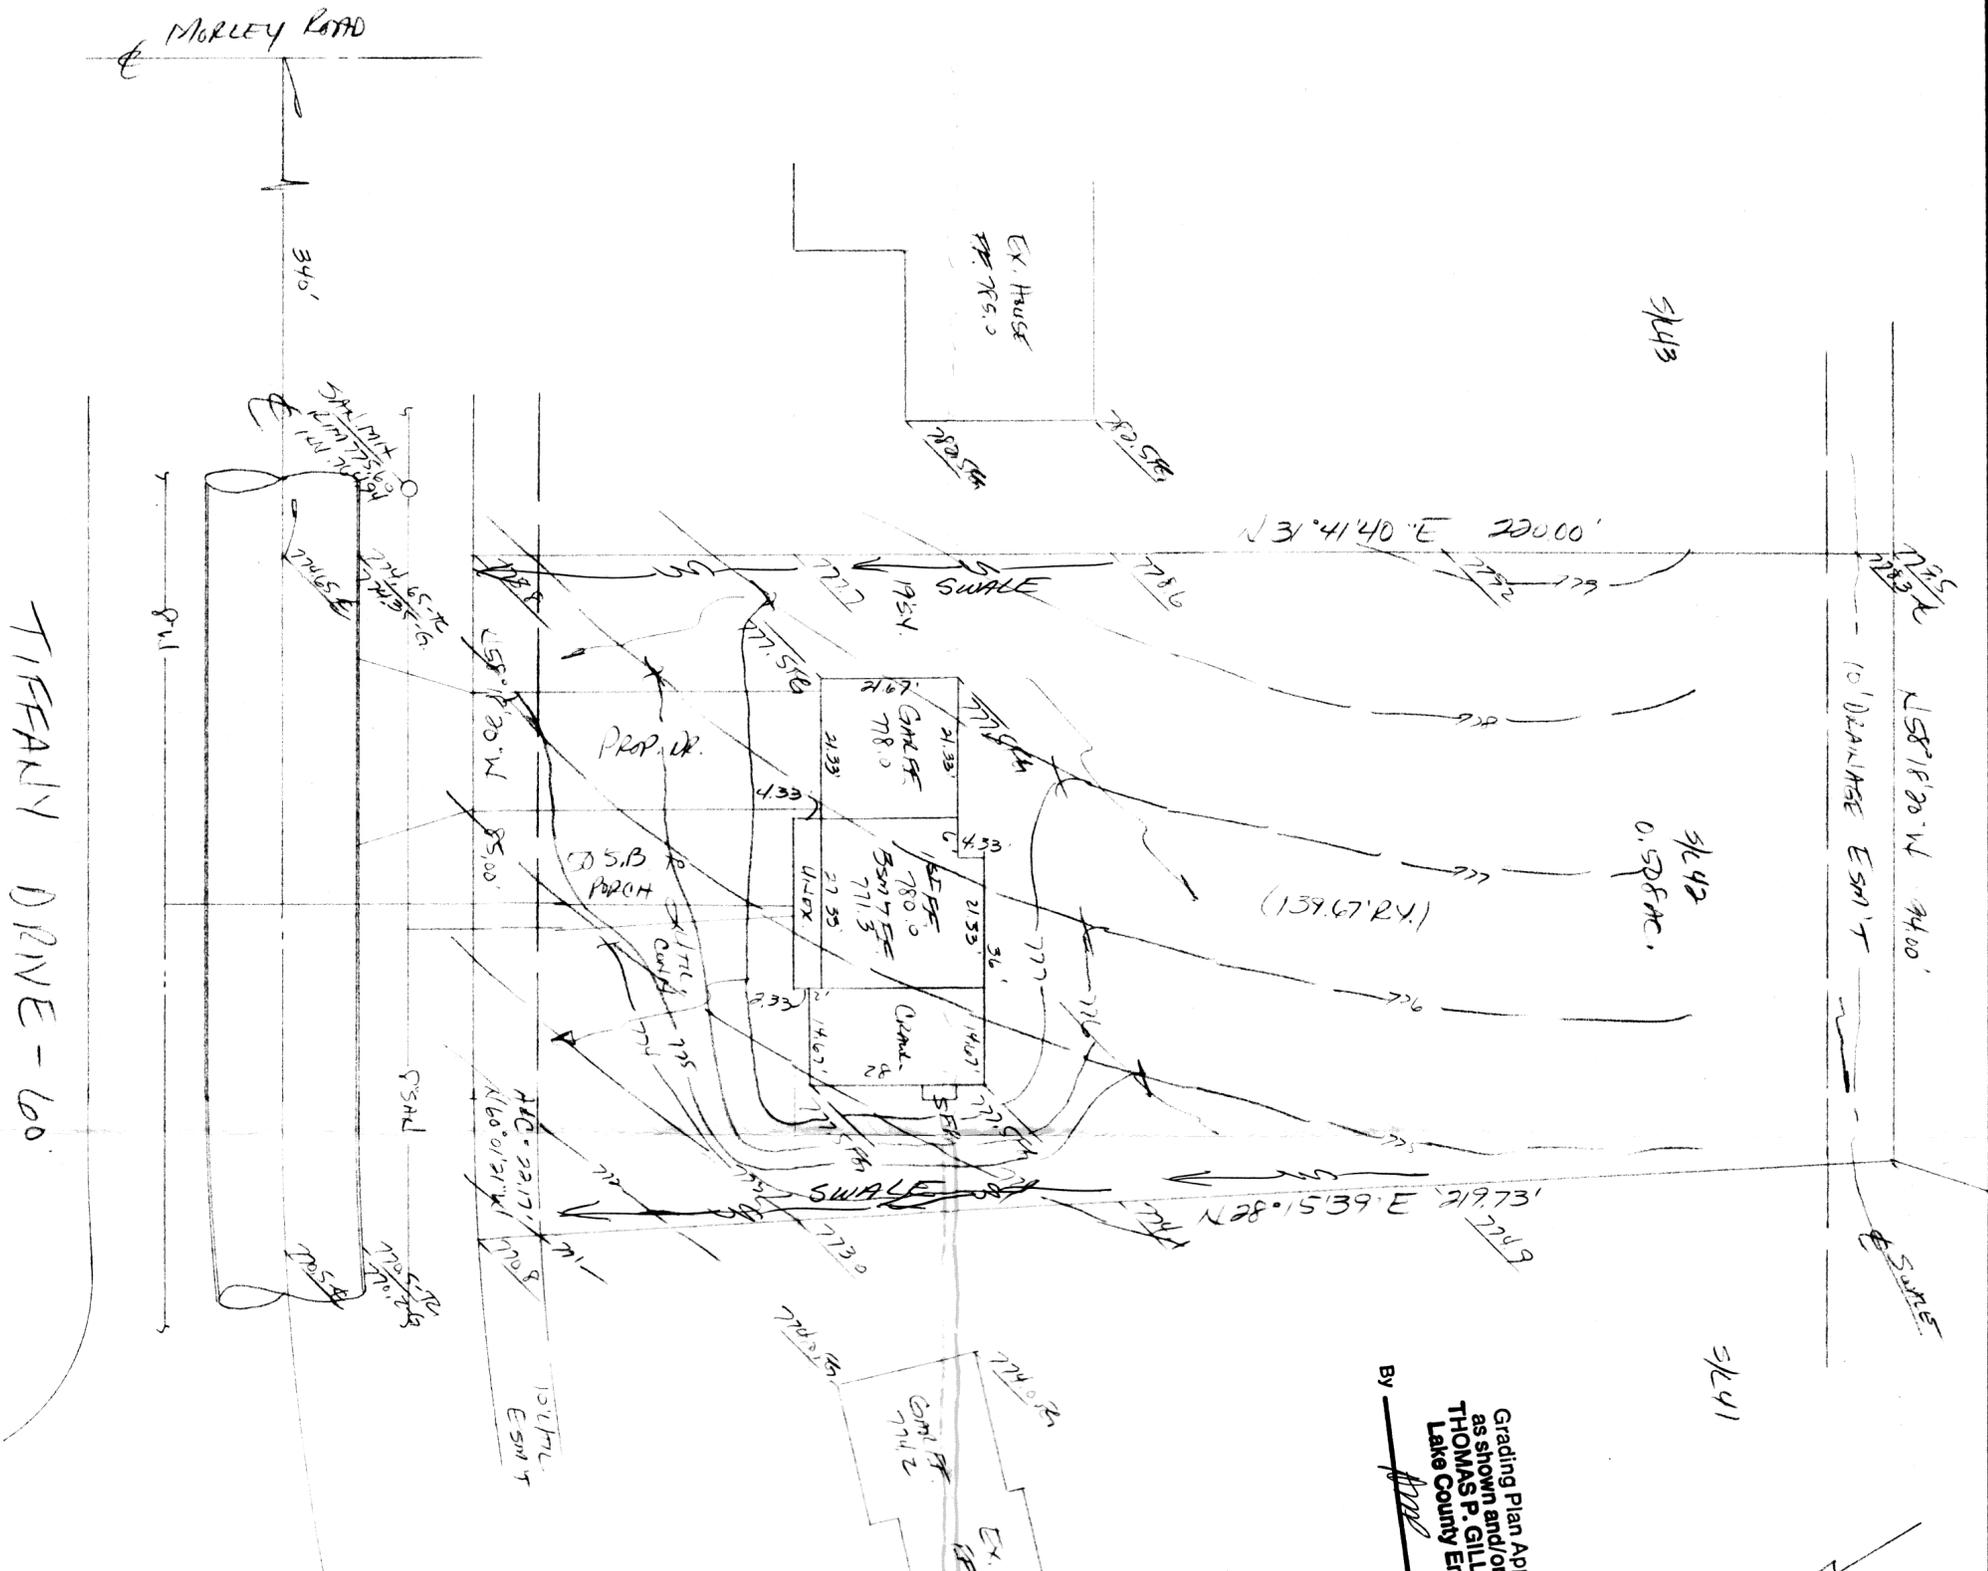

Grading Plan Approved as shown and/or noted  
 THOMAS P. GILLES, P.E.  
 Lake County Engineer  
 Date 9-2-87