Ex 885.77 Z 3 253 150.00 189°26153°E ガガ DRAILAGE ESM'T 36"5TM 30 230 g 24.67 1. 200 X 10 23.33 14,67 NO 33'07'L (51RY.) The BM 7 241 14 135'SC 26.276 AC 0.56 2923 Di. 00-E 8 100. 100. 1.000 五在 T A S °26(53°E\ 885.75 Sona 1 HVEYO Grading Plan Approved as shown and/or noted THOMAS P. GILLES, P.E. Lake County Engineer 489 7 "AS BUILT" CERTIFICATION

I, HEREBY CERTIFY THAT THE CIRCLED GRADES ARE EXISTING
FINISH GRADES CHECKED IN THE FIELD ON \_\_\_\_\_\_\_, 19 \_\_\_\_\_\_,
AND ARE CORRECT TO THE BEST OF MY KNOWLEDGE AND BELIEF. REGISTERED SURVEYOR SUBDIVISION 10-44 NAME
SUBDIVISION 10-44 NAME
VOLTAGO ON LIAM
STREET Date 3-797 BEARINGS
TIE TO NEAREST STREET
SUBLOT NO. PARCEL NO.
SURROUNDING OWNERS
BLDG. DIMENSIONS FIN. GR.
BLDG. TIES FL'R. GRADES
APRON TYPE WIDTH THICKNESS
SIDEWALK TYPE WIDTH THICKNESS
CULVERT TYPE DIA., LENGTH
ROCK OUTCROPPINGS Ö SANITARY MANHOLE NO. OF BEDROOMS Contesses LOCATIONS AS SHOWN OF ADJACENT WELLS AND SEPTIC TANKS OBTAINED FROM LAKE COUNTY HEALTH DEPARTMENT ALL BOUNDARY DATA SHOWN WAS OBTAINED FROM (DEEDS, RECORDED SUBDIVISION PLAT OR OTHER PUBLIC RECORDS) for: DATE REVISIONS DESIGN CERTIFICATION

THIS PLAT WAS PREPARED BY ME, AND IS CORRECT


TO THE BEST OF MY KNOWLEDGE AND BELIEF.

NAME

SURVEYOR REGISTRATION NO. NAME MANHOLE ELEI, ADDRESS # CEHTONENT ISSUED\_ OCHSHIP. ŧ CHIEF CHK'D. 89R 04 DRAWN BY ZONING PERMIT 0397 -8651 BABCOCK • JONES & ASSOCIATES, INC. SITE - 2/2 3-77-97 CHECK LIST REMARKS LEGEND STREET A3 00 PLAN WATER MAIN SIZE, LOCATION
SAN, SEWER SIZE % GR. LOC.
SAN, MH. CAST, ELEV. INV. ELEV.
SAN, CONN. SIZE, LOC. DEPTH
STORM SEWER SIZE % GR. LOC.
STORM MH. CAST ELEV. INV. ELEV.
PAVT TYPE GRADE CURBS
GAS LINE LOC. SIZE PRESSURE
SEPTIC TANK LOCATION & DUPLICATION AREA
WELL LOCATION
ISOLATION RADIUS FROM WELL BUILDING JAK WATER VALVE (GAS)
WATER METER (GAS) AS BUILT ELEVATION PERM. PARCEL NO. DATE ///3/97 VOLUME 덛 PLAN PREPARED BY: 4Mr AKE COUNTY, OHIO APP'D. PAINESVILLE, OHIO INDICATES
DIRECTION OF F SURFACE DRAINAGE CITY PHONE NO. 357-1811 DRAWING NO. B-158-95 STREET TRACT PAGE 1800

Lake County Sanitary Eng. Lake County Eng. Dept. Lower County Planning Comm. Lake County Bldg, Dept. L

SUBJECT TO APPROVAL BY:

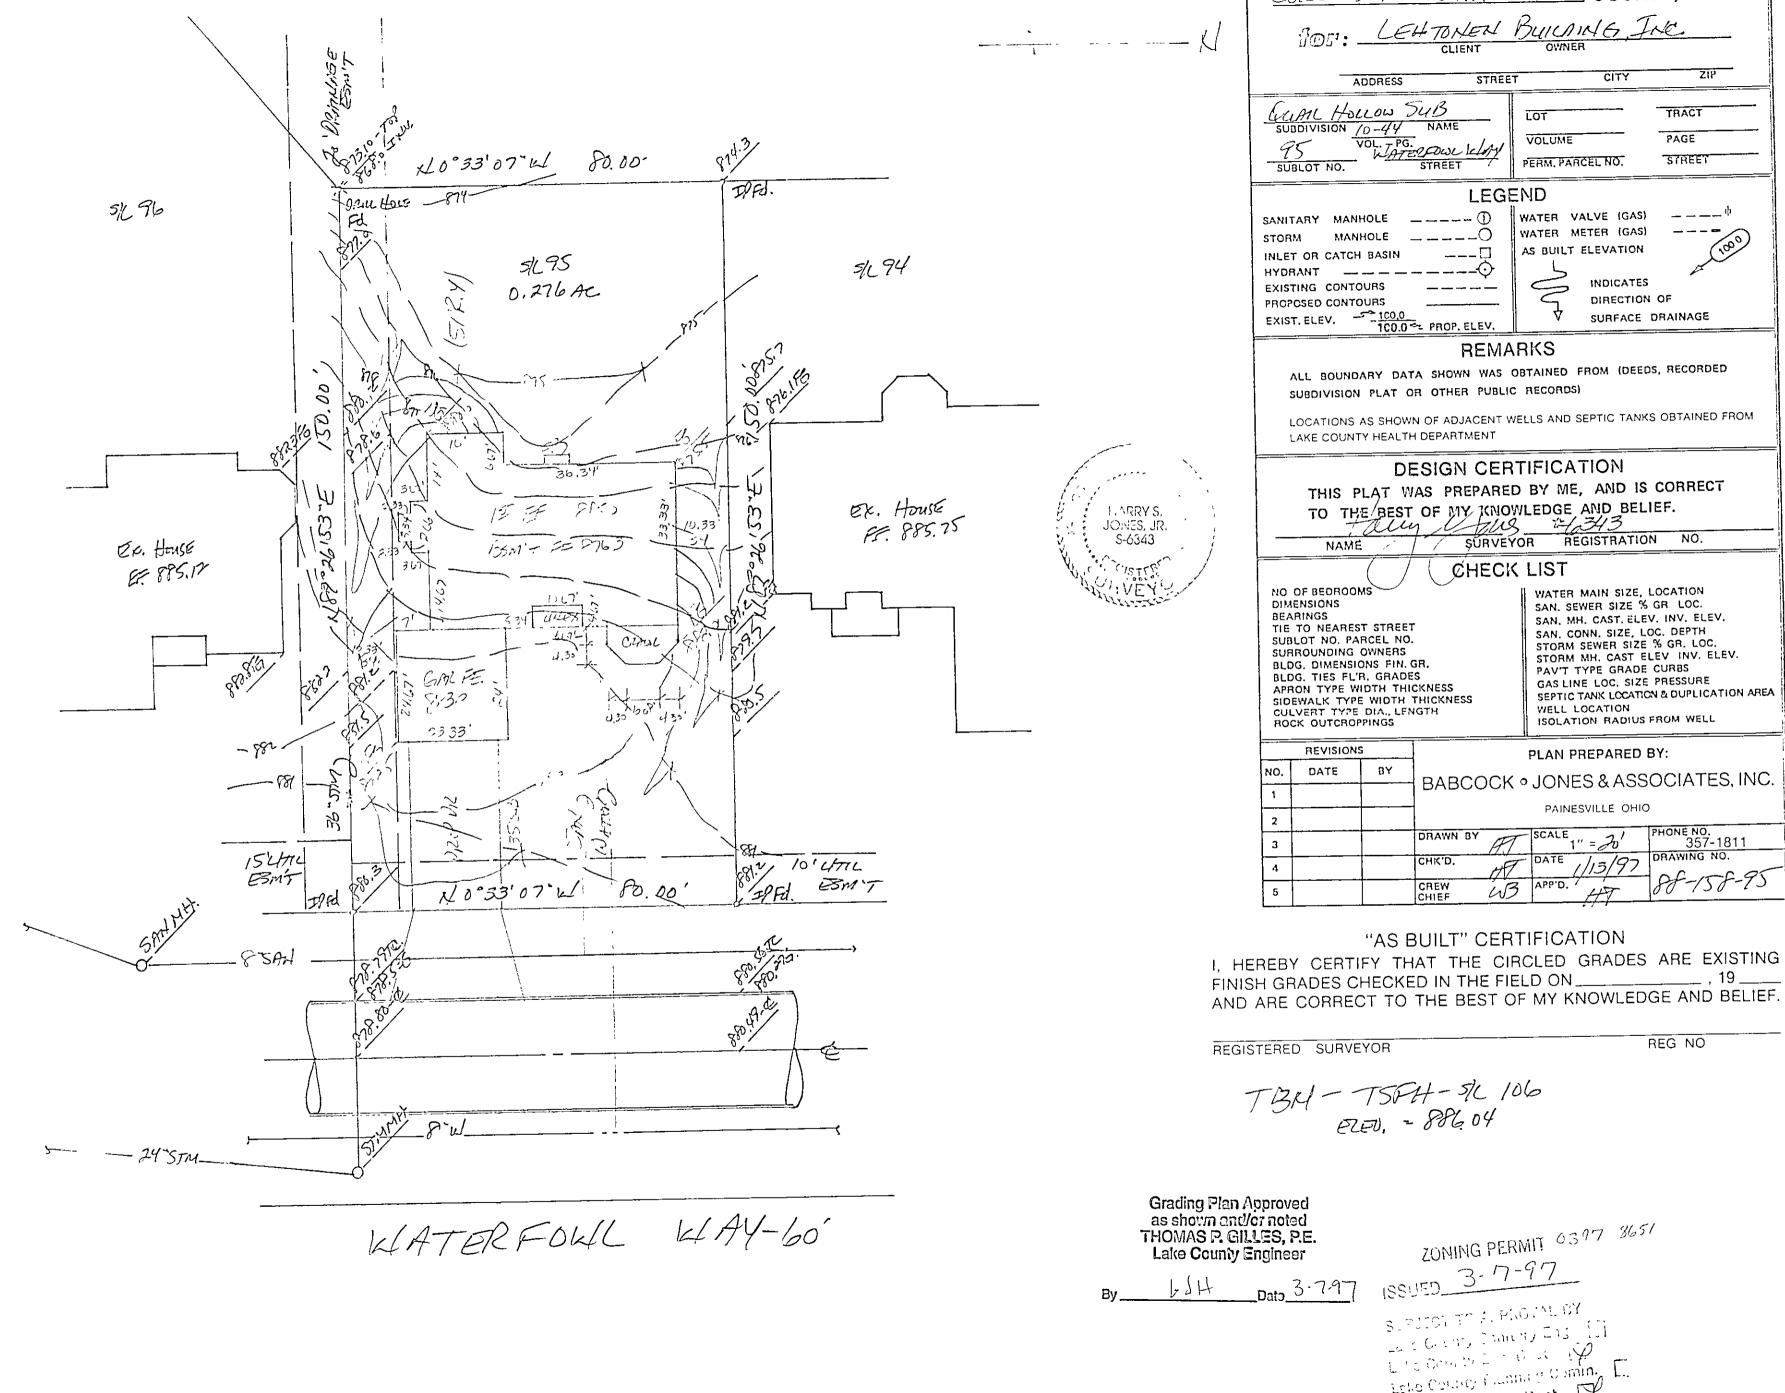

SITE PLAN

CONCORD TOWNSHIP, LAKE COUNTY, OHIO

SEPTIC TANK LOCATION & DUPLICATION AREA

REVISIONS			PLAN PREPARED BY:
NO.	DATE	BY	BABCOCK • JONES & ASSOCIATES, INC.
1			PAINESVILLE OHIO
2			Involve NO
3			DRAWN BY AT SCALE 1" = 20' PHONE NO. 357-1811
4			CHK'D. DATE //13/97 DRAWING NO.
5			CHIEF WS APP'D. HT

AND ARE CORRECT TO THE BEST OF MY KNOWLEDGE AND BELIEF.

Leke Courte Flanning Comin, E. Lake County Bldg, Dept