

SITE PLAN

PAINESVILLE LAKE COUNTY, OHIO
 for: SPEAR BUILDERS
 7581 MIDDLE RIDGE RD, MADISON 44057
 ADDRESS CITY ZIP

IMPERIAL WOODS SUBD. NO. 1
 SUBDIVISION 1-24 NAME
 VOL. PG. NELMAR DRIVE
 32 STREET NO. STREET
 PERM. PARCEL NO. STREET

LOT _____ TRACT _____
 VOLUME _____ PAGE _____
 PERM. PARCEL NO. STREET

LEGEND
 SANITARY MANHOLE
 STORM
 INLET OR CATCH BASIN
 HYDRANT
 EXISTING CONTOURS
 PROPOSED CONTOURS
 EXIST. ELEV. 1000.0
 PROP. ELEV. 1000.0

WATER VALVE (GAS)
 WATER METER (GAS)
 AS BUILT ELEVATION
 INDICATES DIRECTION OF SURFACE DRAINAGE

REMARKS
 ALL BOUNDARY DATA SHOWN WAS OBTAINED FROM IDEEDS, RECORDED SUBDIVISION PLAT OR OTHER PUBLIC RECORDS!
 LOCATIONS AS SHOWN OF ADJACENT WELLS AND SEPTIC TANKS OBTAINED FROM LAKE COUNTY HEALTH DEPARTMENT

DESIGN CERTIFICATION
 THIS PLAN WAS PREPARED BY ME, AND IS CORRECT TO THE BEST OF MY KNOWLEDGE AND BELIEF
 NAME SURVEYOR REGISTRATION NO.

CHECK LIST

NO. OF BEDROOMS	WATER MAIN SIZE, LOCATION
BEARINGS	SAN. SEWER SIZE & GR. LOC.
THE TO NEAREST STREET	SAN. MH. CAST. ELEV. INV. ELEV.
SUBJECT NO. PARCEL NO.	SAN. CONN. SIZE, LOC. DEPTH
SURROUNDING OWNERS	STORM SEWER SIZE & GR. LOC.
BLDG. DIMENSIONS FIN. GR.	STORM MH. CAST. ELEV. INV. ELEV.
BLDG. TIES F.L.R. GRADES	PAV'TY TYPE GRADE CURBS
APRON TYPE WIDTH THICKNESS	GAS LINE LOC. SIZE PRESSURE
CULVERT TYPE DIA. LENGTH	SEPTIC TANK LOCATION & DUPLICATION AREA
ROCK OUTCROPPINGS	WELL LOCATION
	ISOLATION RADII FROM WELL

PLAN PREPARED BY:
 DEBEVEC • SALO & ASSOCIATES, INC.
 126 E. ERIE ST. PAINESVILLE, OHIO


NO.	DATE	BY
1		
2		
3		
4		
5		

SCALE 20'
 DRAWN BY: DATE: JULY 1985
 CHK'D. DATE: JULY 1985
 APP'D. DATE: JULY 1985

"AS BUILT" CERTIFICATION
 I, HEREBY CERTIFY THAT THE CIRCLED GRADES ARE EXISTING FINISH GRADES CHECKED IN THE FIELD ON 1985 AND ARE CORRECT TO THE BEST OF MY KNOWLEDGE AND BELIEF.


REGISTERED SURVEYOR REG. NO. _____

This Permit Expires
 NOV 07 1987
 PAINESVILLE TOWNSHIP
 ZONING APPROVED
 # 655
 Zoning Inspector 7/7/86

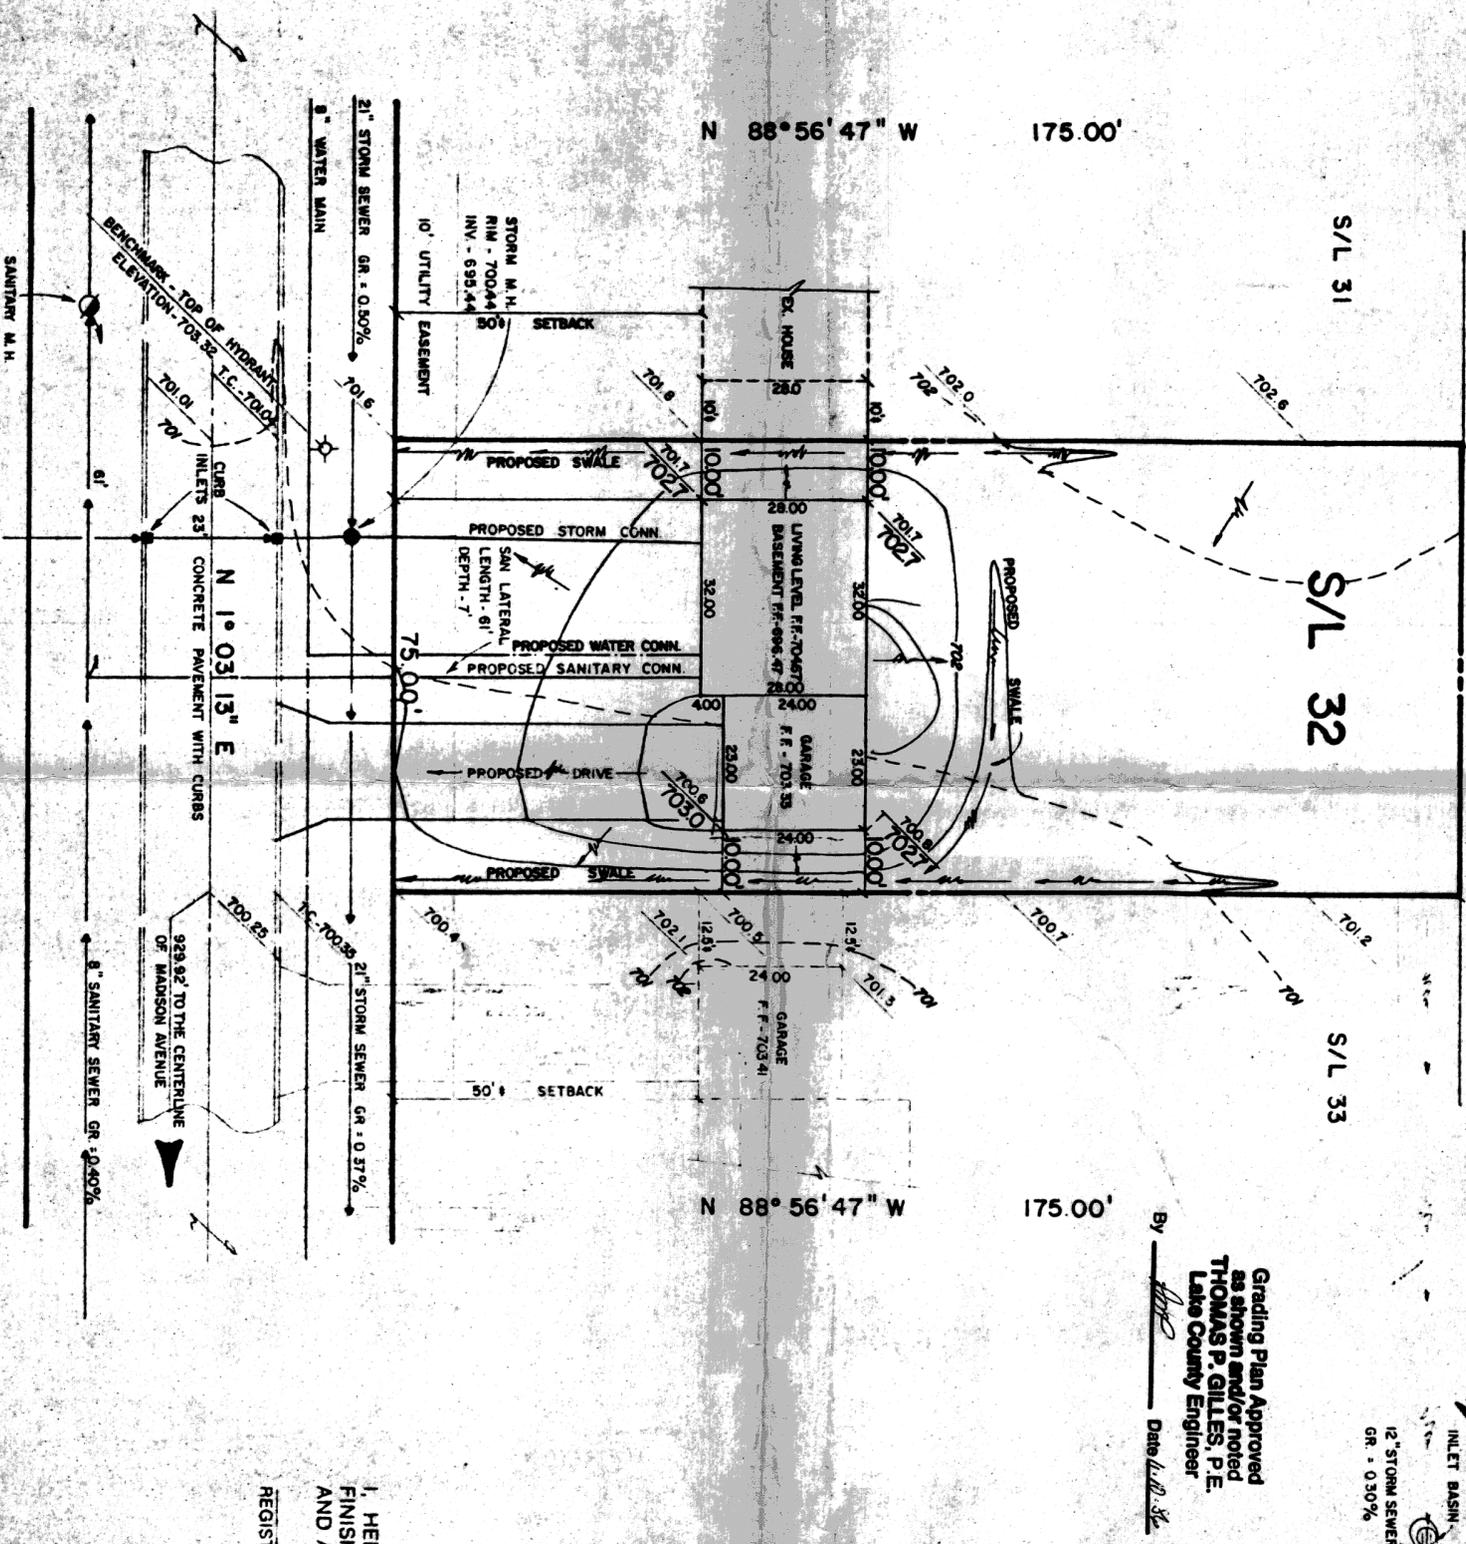

Grading Plan Approved
 as shown and/or noted
 THOMAS P. GILLES, P.E.
 Lake County Engineer

By: [Signature]
 Date: 7/1/86

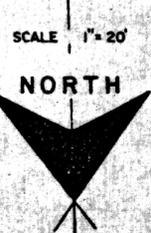

NELMAR DRIVE 60'